

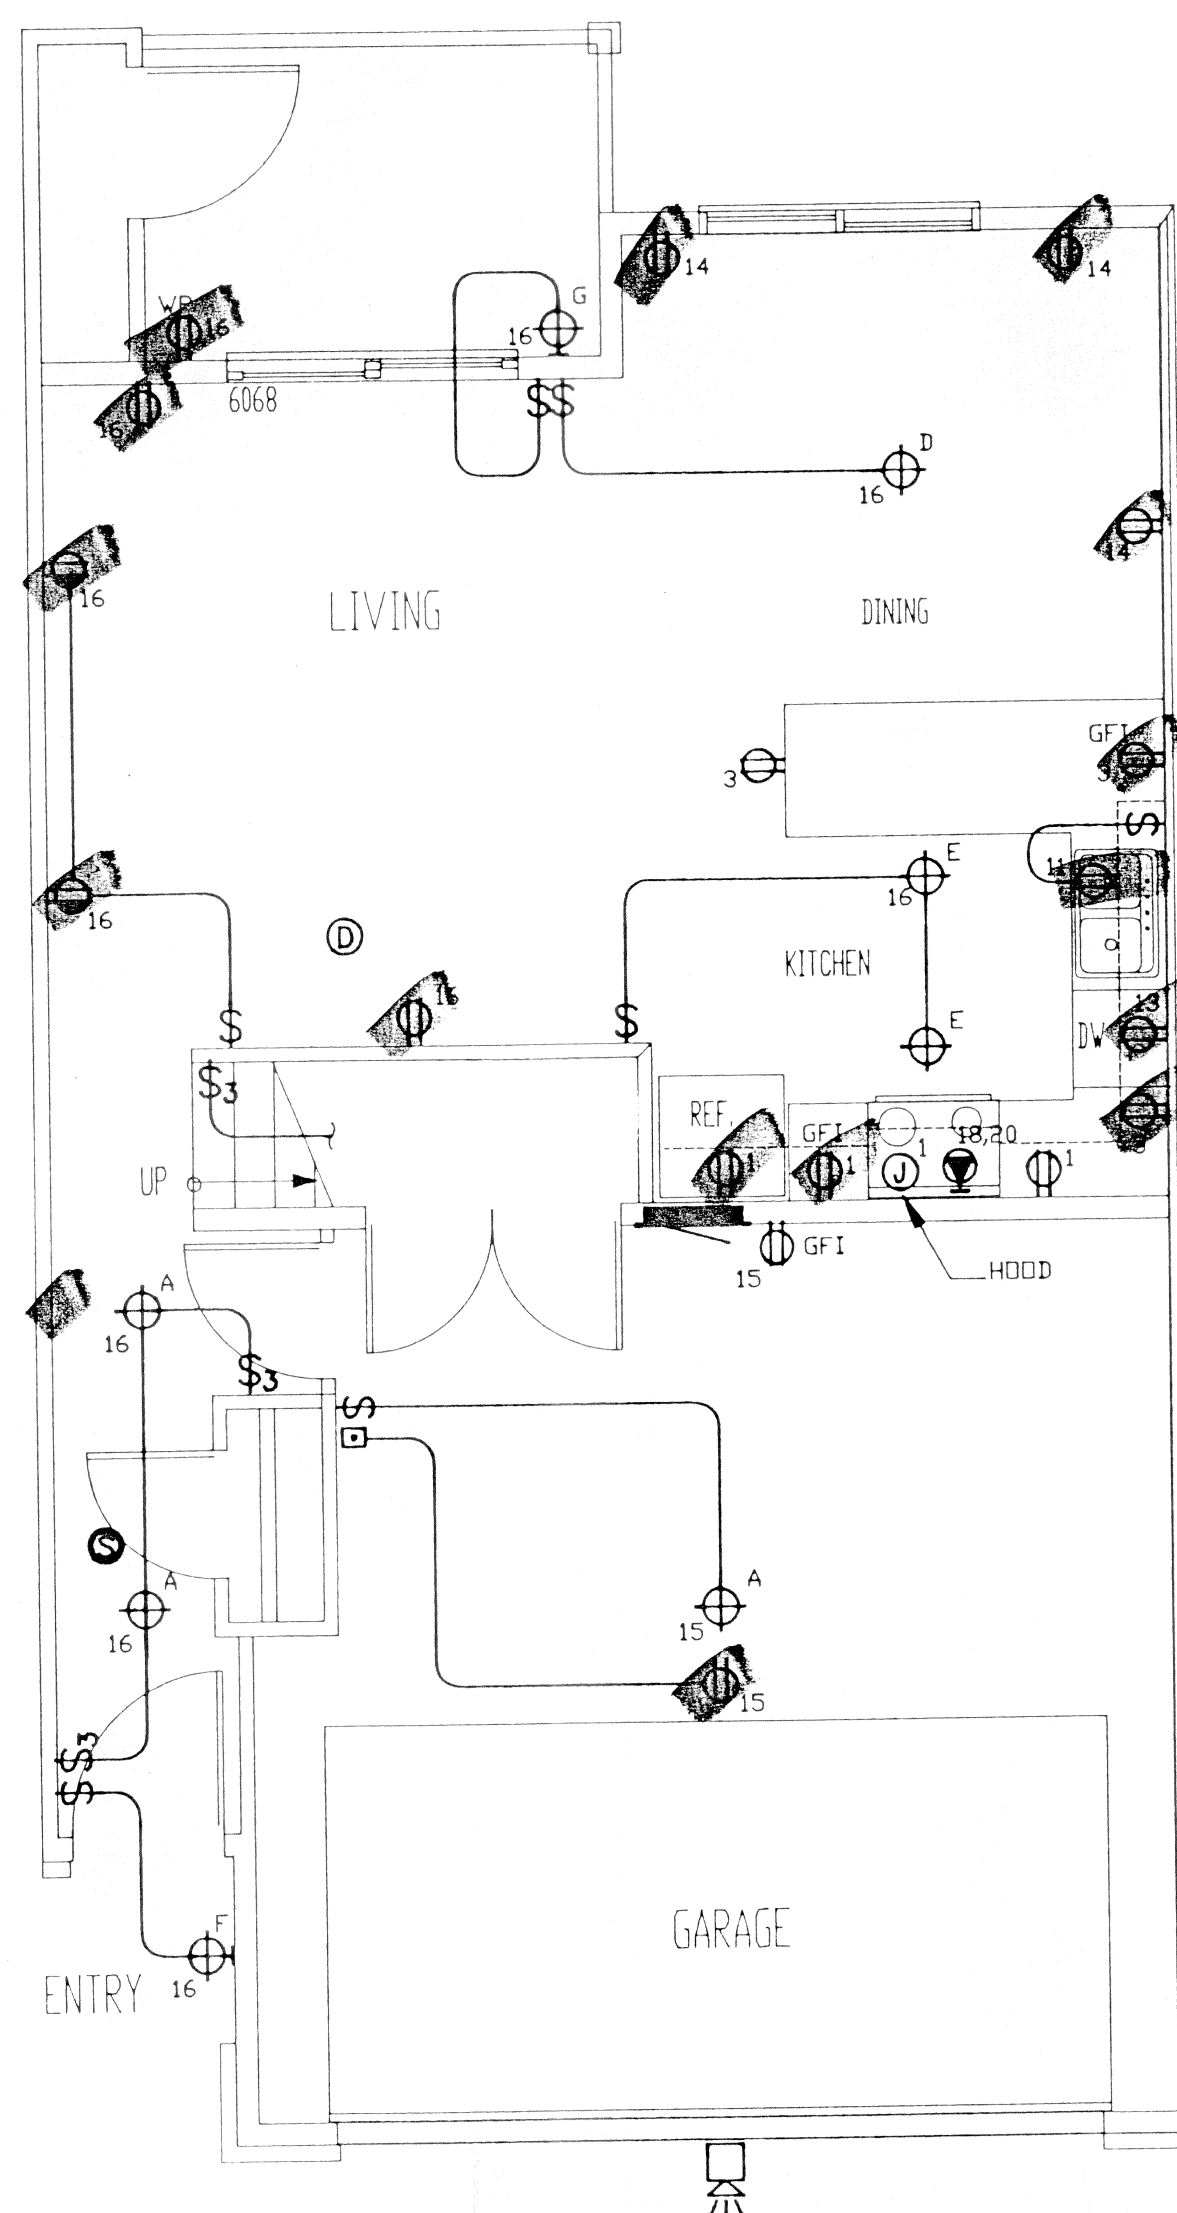


DESIGN GROUP INC
ELECTRICAL-DESIGN
P.O. BOX 764
GLENWOOD SPRINGS
COLO. 81601

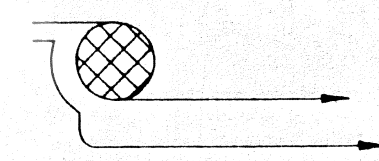

LOWER LEVEL
BUILDINGS 1,2,3 & 4

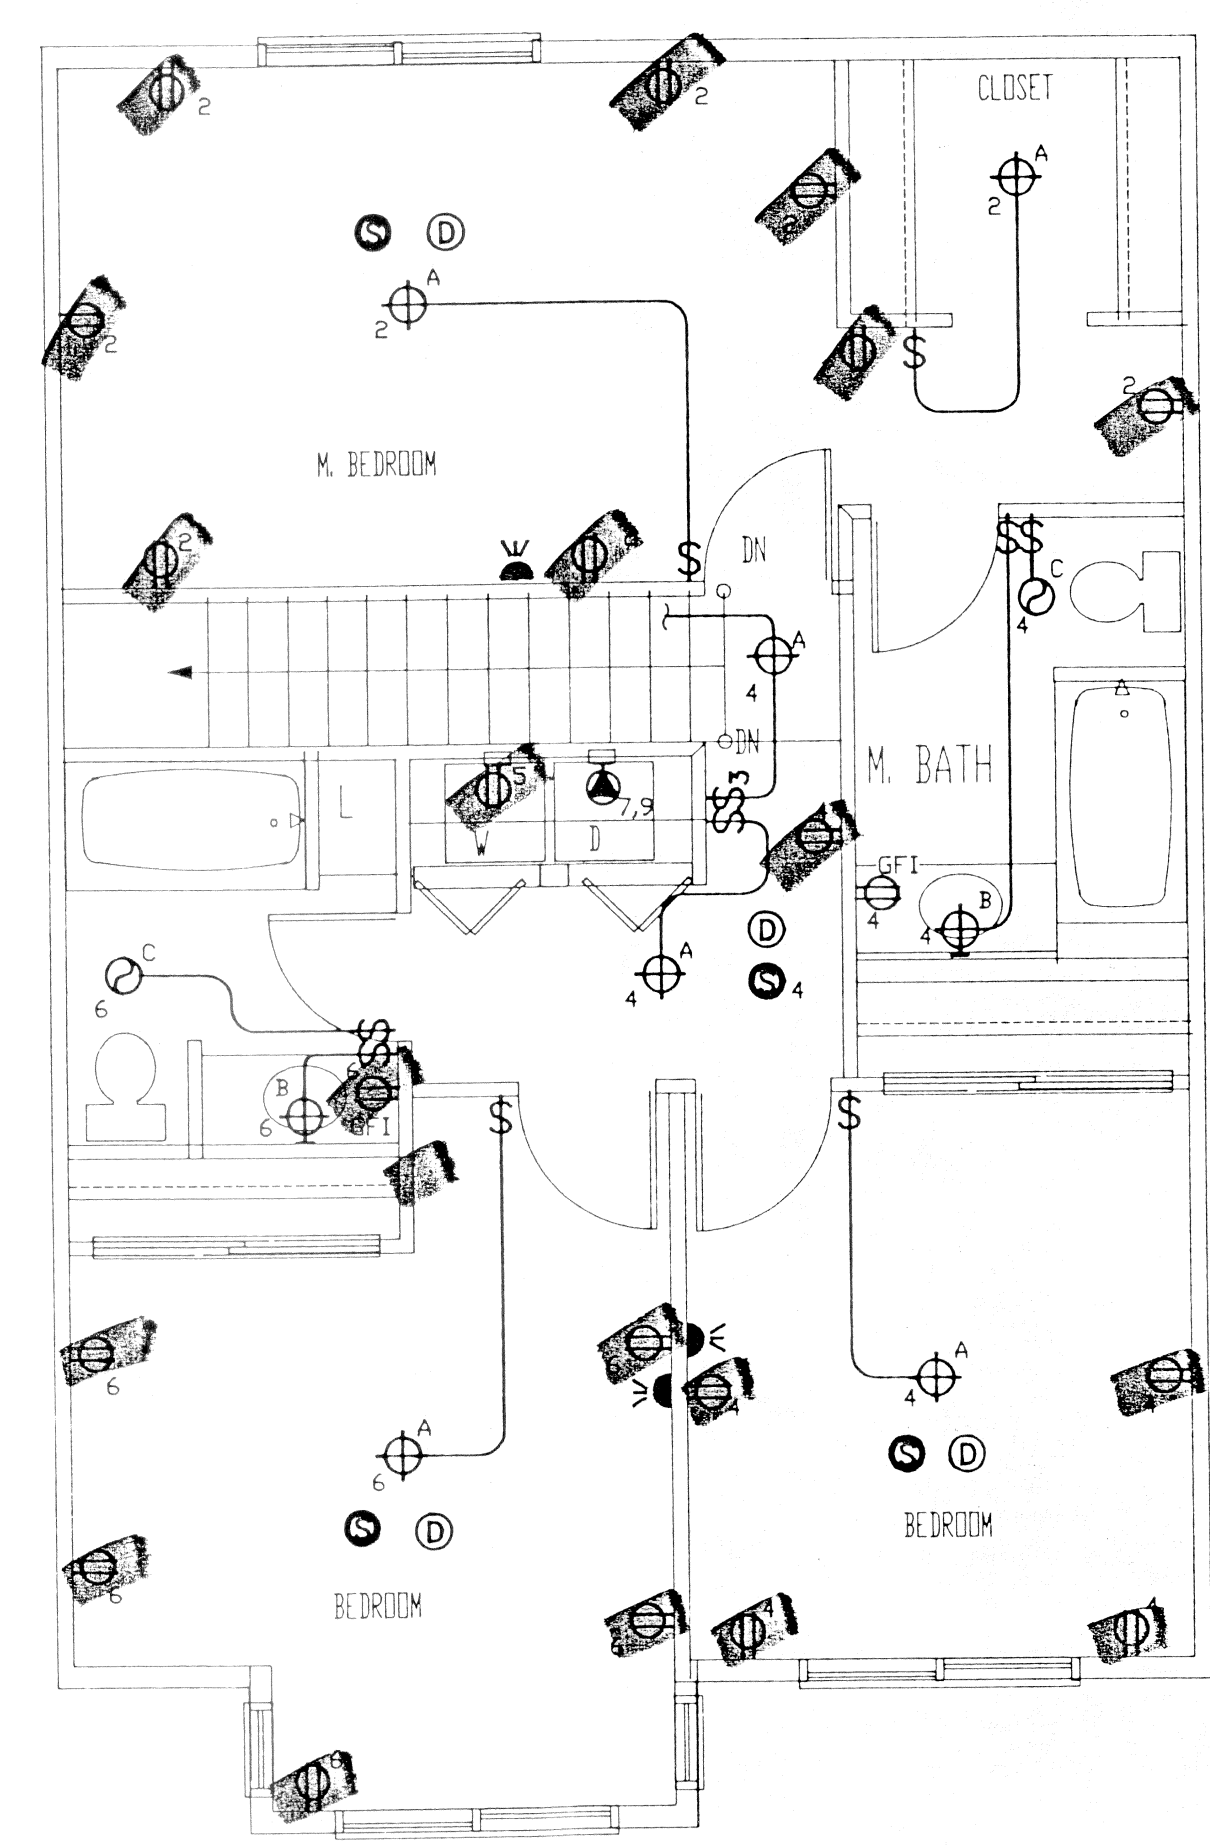

UPPER LEVEL
BUILDINGS 1,2,3 & 4


Smoke detectors are required
in each bedroom, bedroom
corridor, on every level,
wired to electrical system
and have battery back-up
Sec. 1210

DATE	REMARKS

MOUNTAIN
HOUSING GROUP
LOT 640C
TELLURIDE MOUNTAIN VILLAGE

JOB #	93184
DRAWN	SW
CHECKED	ROSS HANSEN
PRINTED	3-10-94

SHEET TITLE:
ELECTRICAL PLANS

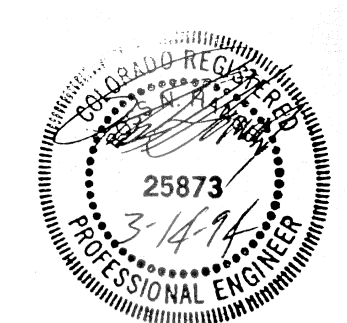

E2.6